



## North Bay Village

Administrative Offices


1666 Kennedy Causeway, Suite 300 North Bay Village, FL 33141

Tel: (305) 756-7171 Fax: (305) 756-7722 Website: [www.nbvillage.com](http://www.nbvillage.com)

### **ELECTRICAL REMODELING NOTES**

- For kitchen cabinet replacement, please submit Two (2) copies of a floor plan showing all devices new (N) and existing (E), GFI's, etc. Spacing shall comply with NEC 210-52 C (See attached Example)
- Plans shall be signed and dated by a Florida Licensed Professional Engineer or a licensed Master Electrician (License number must be included.)
- If electrical work is needed in order to bring existing condition into compliance with current NEC requirements, then an electrical permit application must be submitted.

**EXAMPLE**

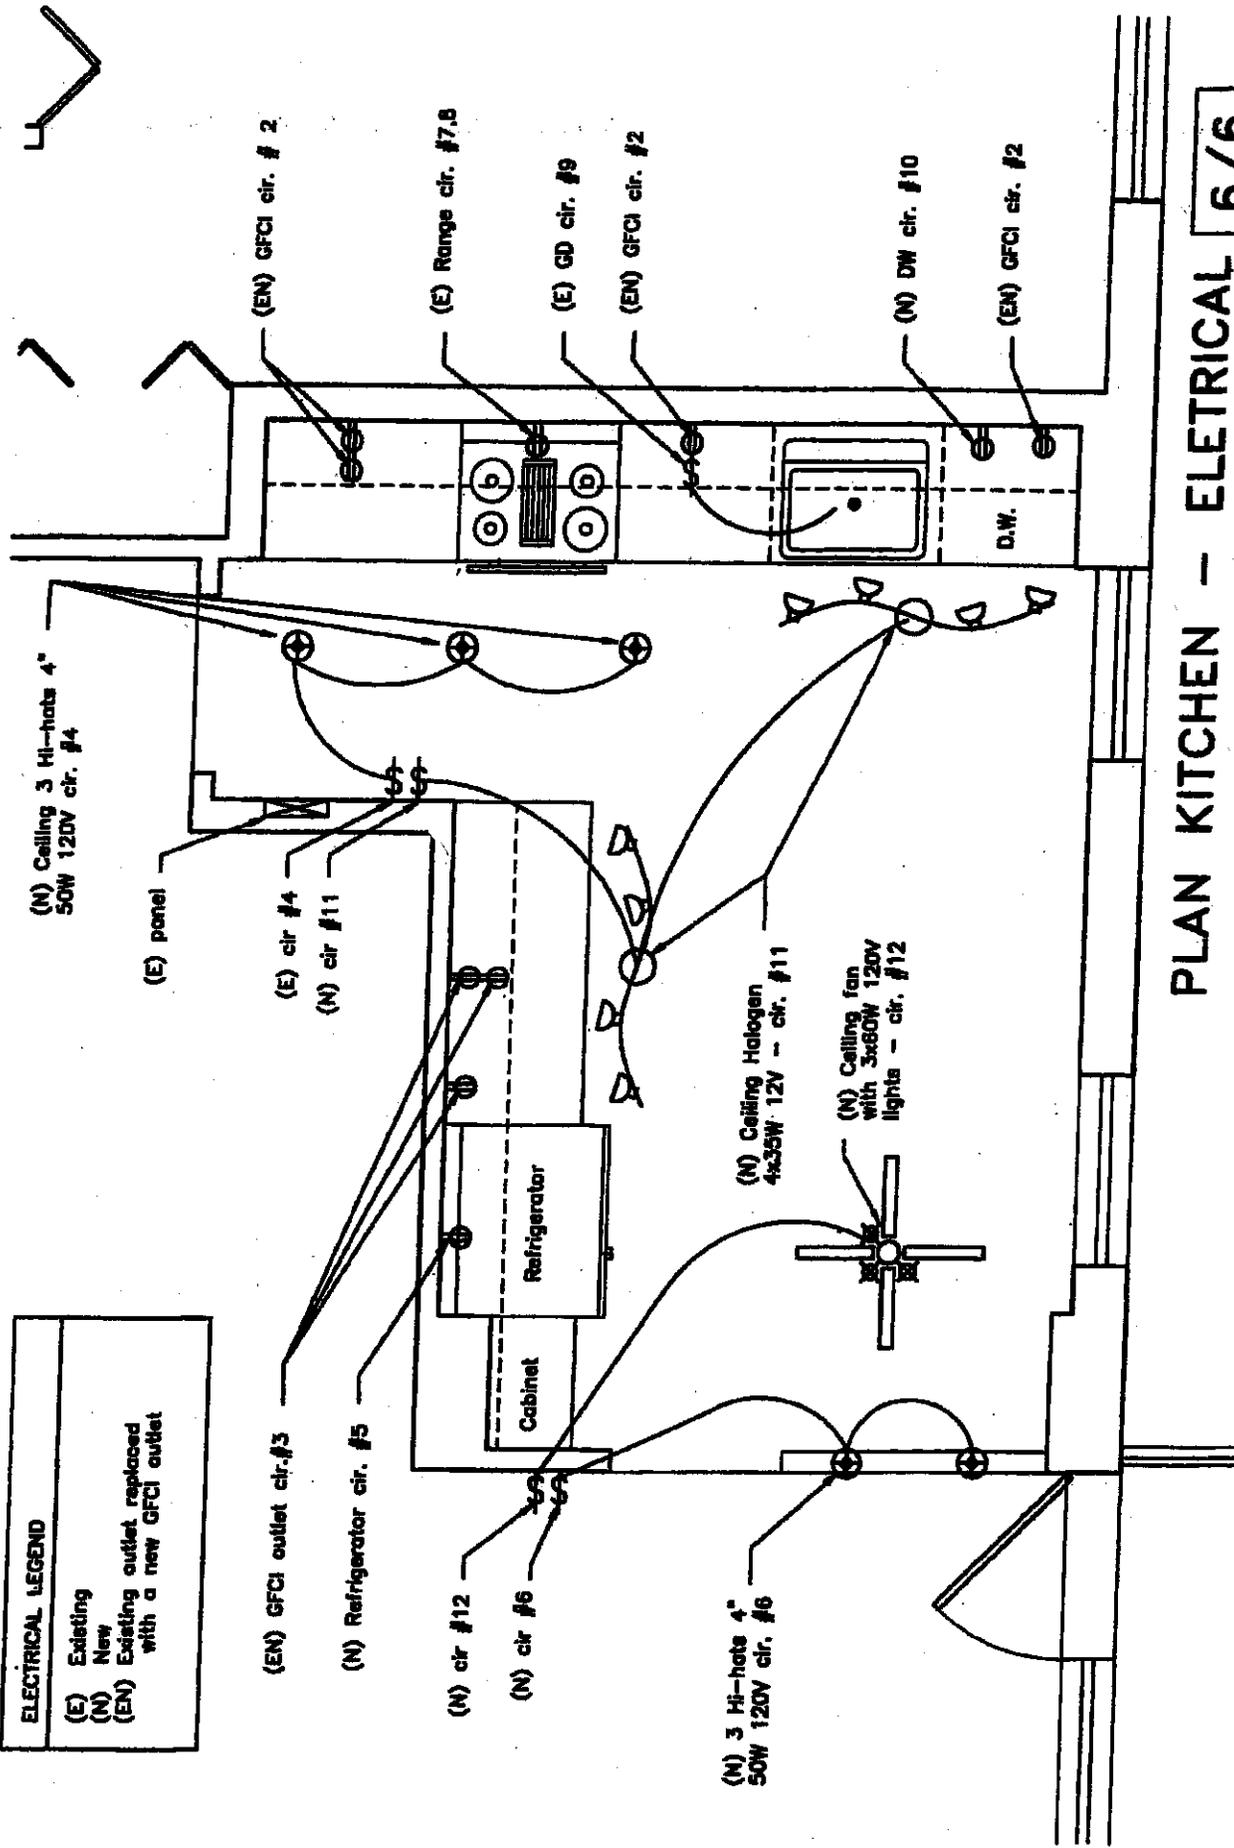

ELECTRICAL LEGEND	
(E)	Existing
(N)	New
(EN)	Existing outlet replaced with a new GFCI outlet

**PLAN KITCHEN - ELECTRICAL**  
**TAMPER RESISTANT DEVICES**  
SCALE 3/8"=1' **6/6**