


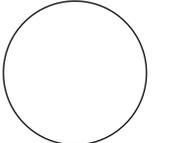

BERMELLO • AJAMIL
& PARTNERS • INC
Architecture Engineering Planning
Interior Design Landscape Architecture
2601 South Bayshore Drive
Miami FL 33133
(305) 859-2050 Fax (305) 860-3759




MONIKA S. GAMBLE R.L.A.
LA0001379

Revisions:

No.	Date	Description
1	May 18, 2010	Perm / Fire Review Comments

Project Name:

Dr. Paul Vogel
Community Park
CITY OF NORTH BAY VILLAGE
LANDSCAPE PLANS

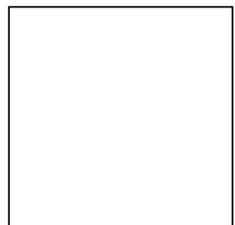

Project No. 29064.000
Scale: As Shown
Date: March 22, 2010
Drawn: JV
Checked: RH, MG
CADD File: H:\PROJECTS\29064 Park
NB\VLandscape Plans
Drawing Title:


SITE FURNITURE
& LIGHTING PLAN

Sheet No. L-5.0

SITE ELEMENTS & LIGHTING SCHEDULE

SYMBOL	QUANTITY	TYPE	SPECIFICATIONS	CONTACT	COLOR
A	1	FUTURE BUILDING Prefabricated unisex restroom with storage (N.I.C. / Not in contract)	Prefabricated men and women restroom with storage, 16.5' x 12.4', raised entry and drinking fountain, pedestal, stainless steel plumbing fixtures, spray, hand dryer, lights, automatic soap dispenser, automatic "No Touch" plumbing fixtures and door openers, anti-microbial stainless steel surfaces, anti-graffiti exterior coat. Note: Building to have PCA (Department of Community Affairs) product certification for a premanufactured building in Miami-Dade County.	The Public Restrooms Company www.PublicRestroomCompany.com 888.888.2060 Fax 888.888.1448 Katie Kaufman	Roofing: Ash Gray metal. Exterior: split face concrete.
B	1	Performance Shelter	#CA2820, 28' X 20' Custom Cambria, 6:12 Roof Pitch, (8) Column Design, 5/8" Tongue and Groove Roof Decking, 26 Gauge Standing Seam Metal Roof, Laser Cut Lattice, 7'-6" Eave Height (Clear ceiling height), Occupancy load: 27 people, Public Use.		
C	1	Hexagonal Shelter	#8031, 21' Hexagonal, Steel Duo Top Shelter, 4:12 Roof Pitch, (6) Column Design, 24 Gauge Standing Seam Metal Roof, Laser Cut Lattice, Powder Coat Finish, 7'-6" Eave Height (Clear ceiling height), Occupancy load: 33 people, Public Use.	KORKAT Rep (Daytona) 947 Beville Rd. Suite 15 S. Daytona, FL 32119 Phone: (386) 322-7789 Fax: (386) 322-4289 erin@ettflorida.com www.korkat.com	Regal White Powder Coat Finish Steel Frame & Regal Blue Metal Roof
D	1	Lookout Shelter	#8116P, 16' Pittsburgh Square Shelter, 6:12 Roof Pitch, (4) Column Design, 24 Gauge Standing Seam Metal Roof, Laser Cut Lattice, Powder Coat Finish 7'-6" Eave Height (Clear ceiling height), Occupancy load: 17 people, Public Use.		
E	2	Picnic Shelter	#8112P, 12' Pittsburgh Square Shelter, 6:12 Roof Pitch, (4) Column Design, 24 Gauge Standing Seam Metal Roof, Powder Coat Finish, 7'-6" Eave Height (Clear ceiling height), Occupancy load: 10 people, Public Use.		Regal White Powder Coat Finish Steel Frame & Ash Gray Metal Roof
F	1	Playground	GameTime / PowerScope Playground / Modified Climb n' Slide # 85236 Aluminum Uprights/ with two (2) 20'x20' SunBox Fabric Sail Roof Built-in.		Metal Posts (Yellow), Accent Metal (Yellow), Plastic (Blue), Deck (Blue), MegaRock (Granite), Fabric SunBox Roof (Lower Turquoise) and Upper Royal Blue)
G	1	Exercise Station	Cardio Walker / M:13167		
H	1	Exercise Station	Seated Chest Press / M:13164		
I	1	Exercise Station	Seated Leg Press / M:13165		
J	1	Exercise Station	Rowing Machine / M:13163	drp Dominica Recreation Products Phone: 800-432-0162 Roy May Ext. 116 roy.m@gametime.com	Metal Posts (Blue), Accent Metal (Beige)
K	4	Trash Receptacle	UltraPlay, Park Furnishings, Surface Mount, Trash Receptacle Model: LX-36RB Rain Bonnet with Cable / Powder Coated Finish.		Dark Grey
L	2	Bike Rack	UltraPlay, Park Furnishings, 5' Loop Bike Rack / Capacity 7 / Model: 5805 / Inground Mount / Powder Coated Finish.		Dark Grey
M	3	Bench	UltraPlay, Park Furnishings, Surface Mount, Hamilton Bench Model: 92C-S6 / Powder Coated Finish.		Dark Grey
N	2	Picnic Table	UltraPlay, Park Furnishings, Surface Mount, Single Pedestal Picnic table Model: 337-CDR6.		Cedar- Recycled Plastic & Dark Grey
O	6	Rocking Chair	Captiva Adirondack Rocker Chair - 4625 SKU# XSH1025 / with cable	Shine Company Inc. EveryRockingChair.com	Light Blue
P	26	Ceiling Wash	Allscape / FL-12 / 26 CF / 120 / BK	The MLS Group 7035A SW 47th Street Miami, Florida 33155 Tel: (305) 666-4210 ext. 118 Roy Bustillo, LC	Black
Q	12	Area Light	Lumec / LEN4-90W48LED4K-3-208-LEDB- BKTX-14GY3TX		GY3TX Textured Medium Grey

WORK ORDER #3 EXCLUSIONS

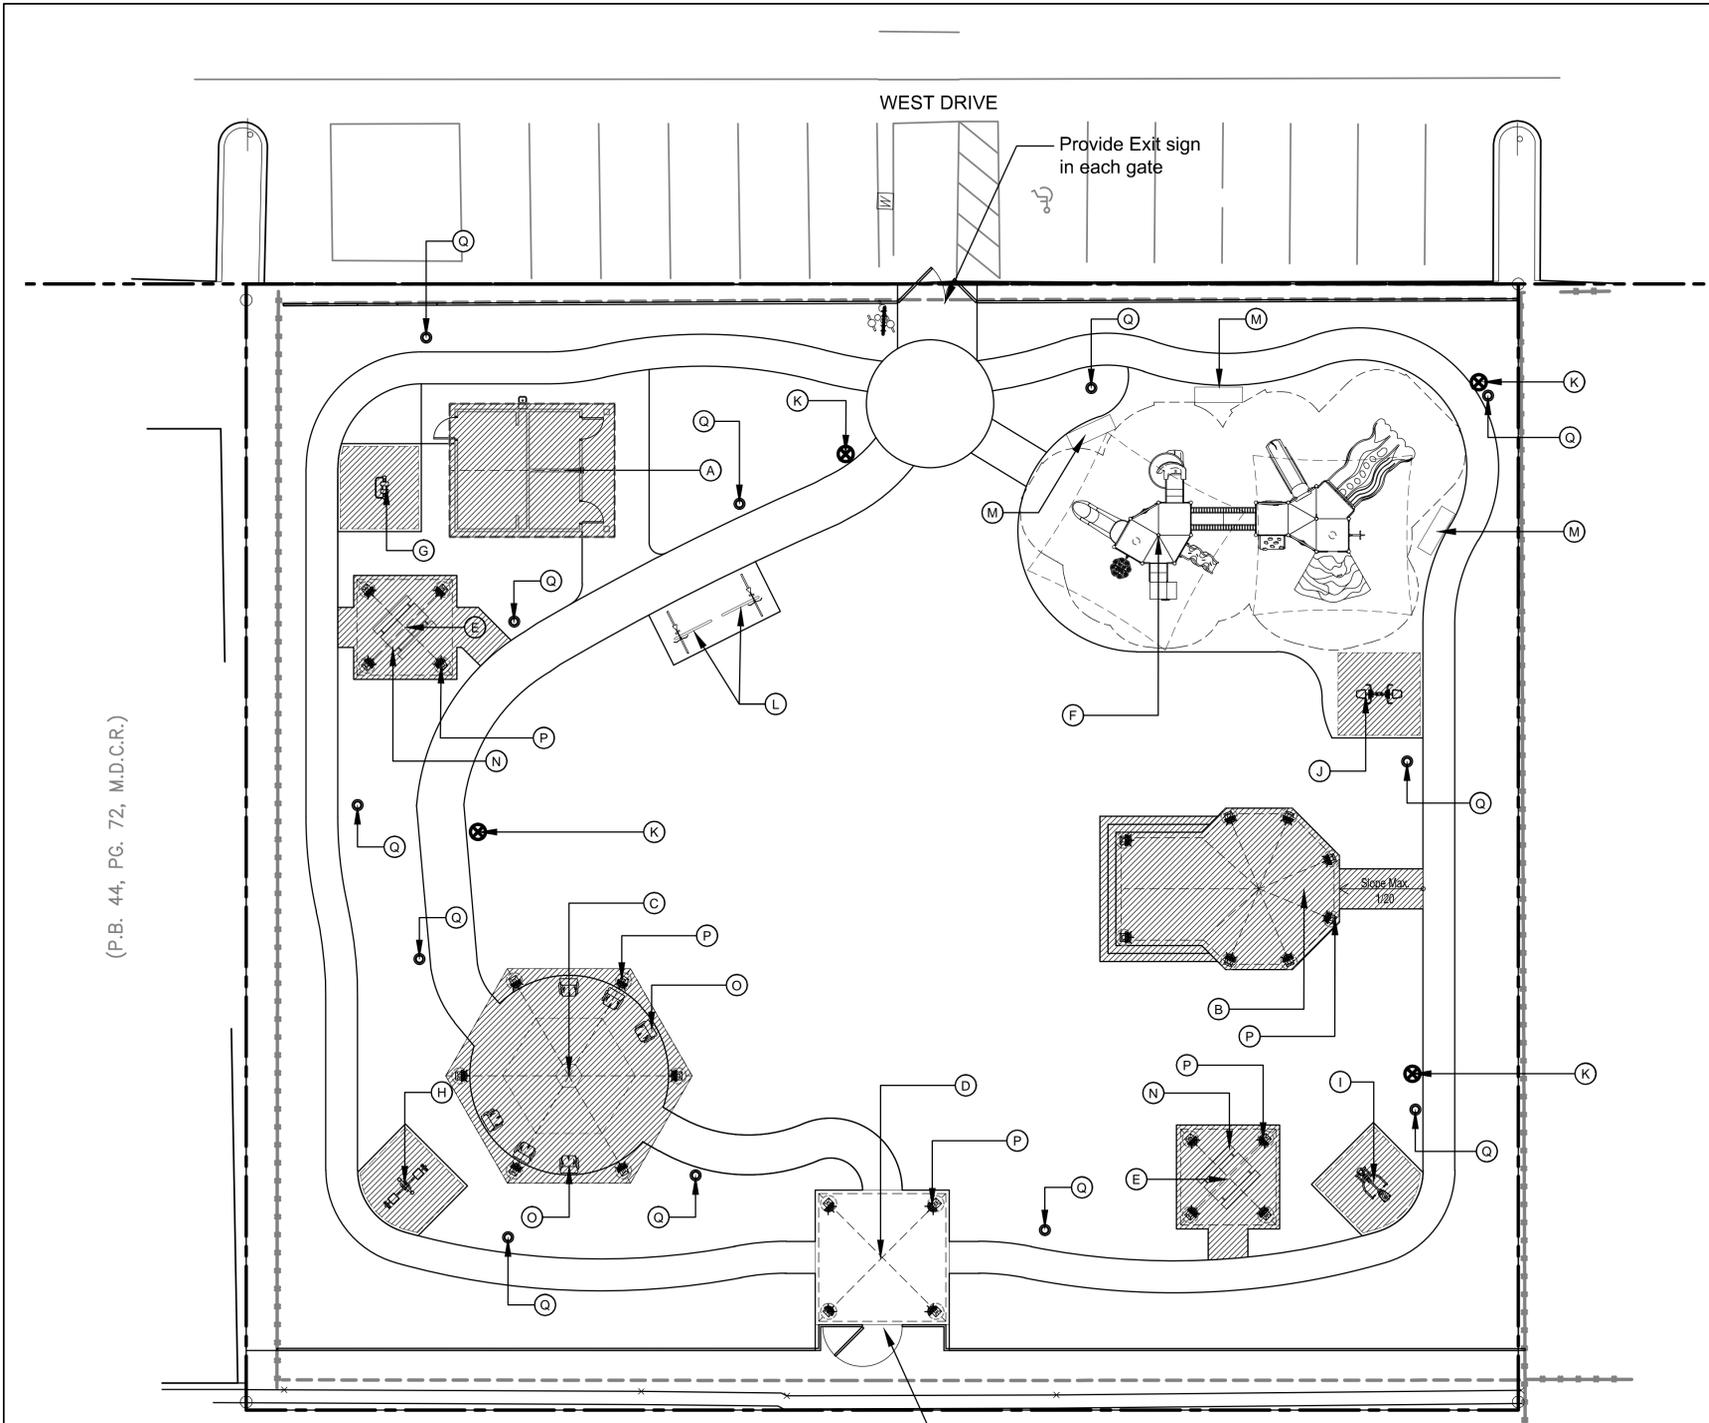

(P.B. 44, PG. 72, M.D.C.R.)

